


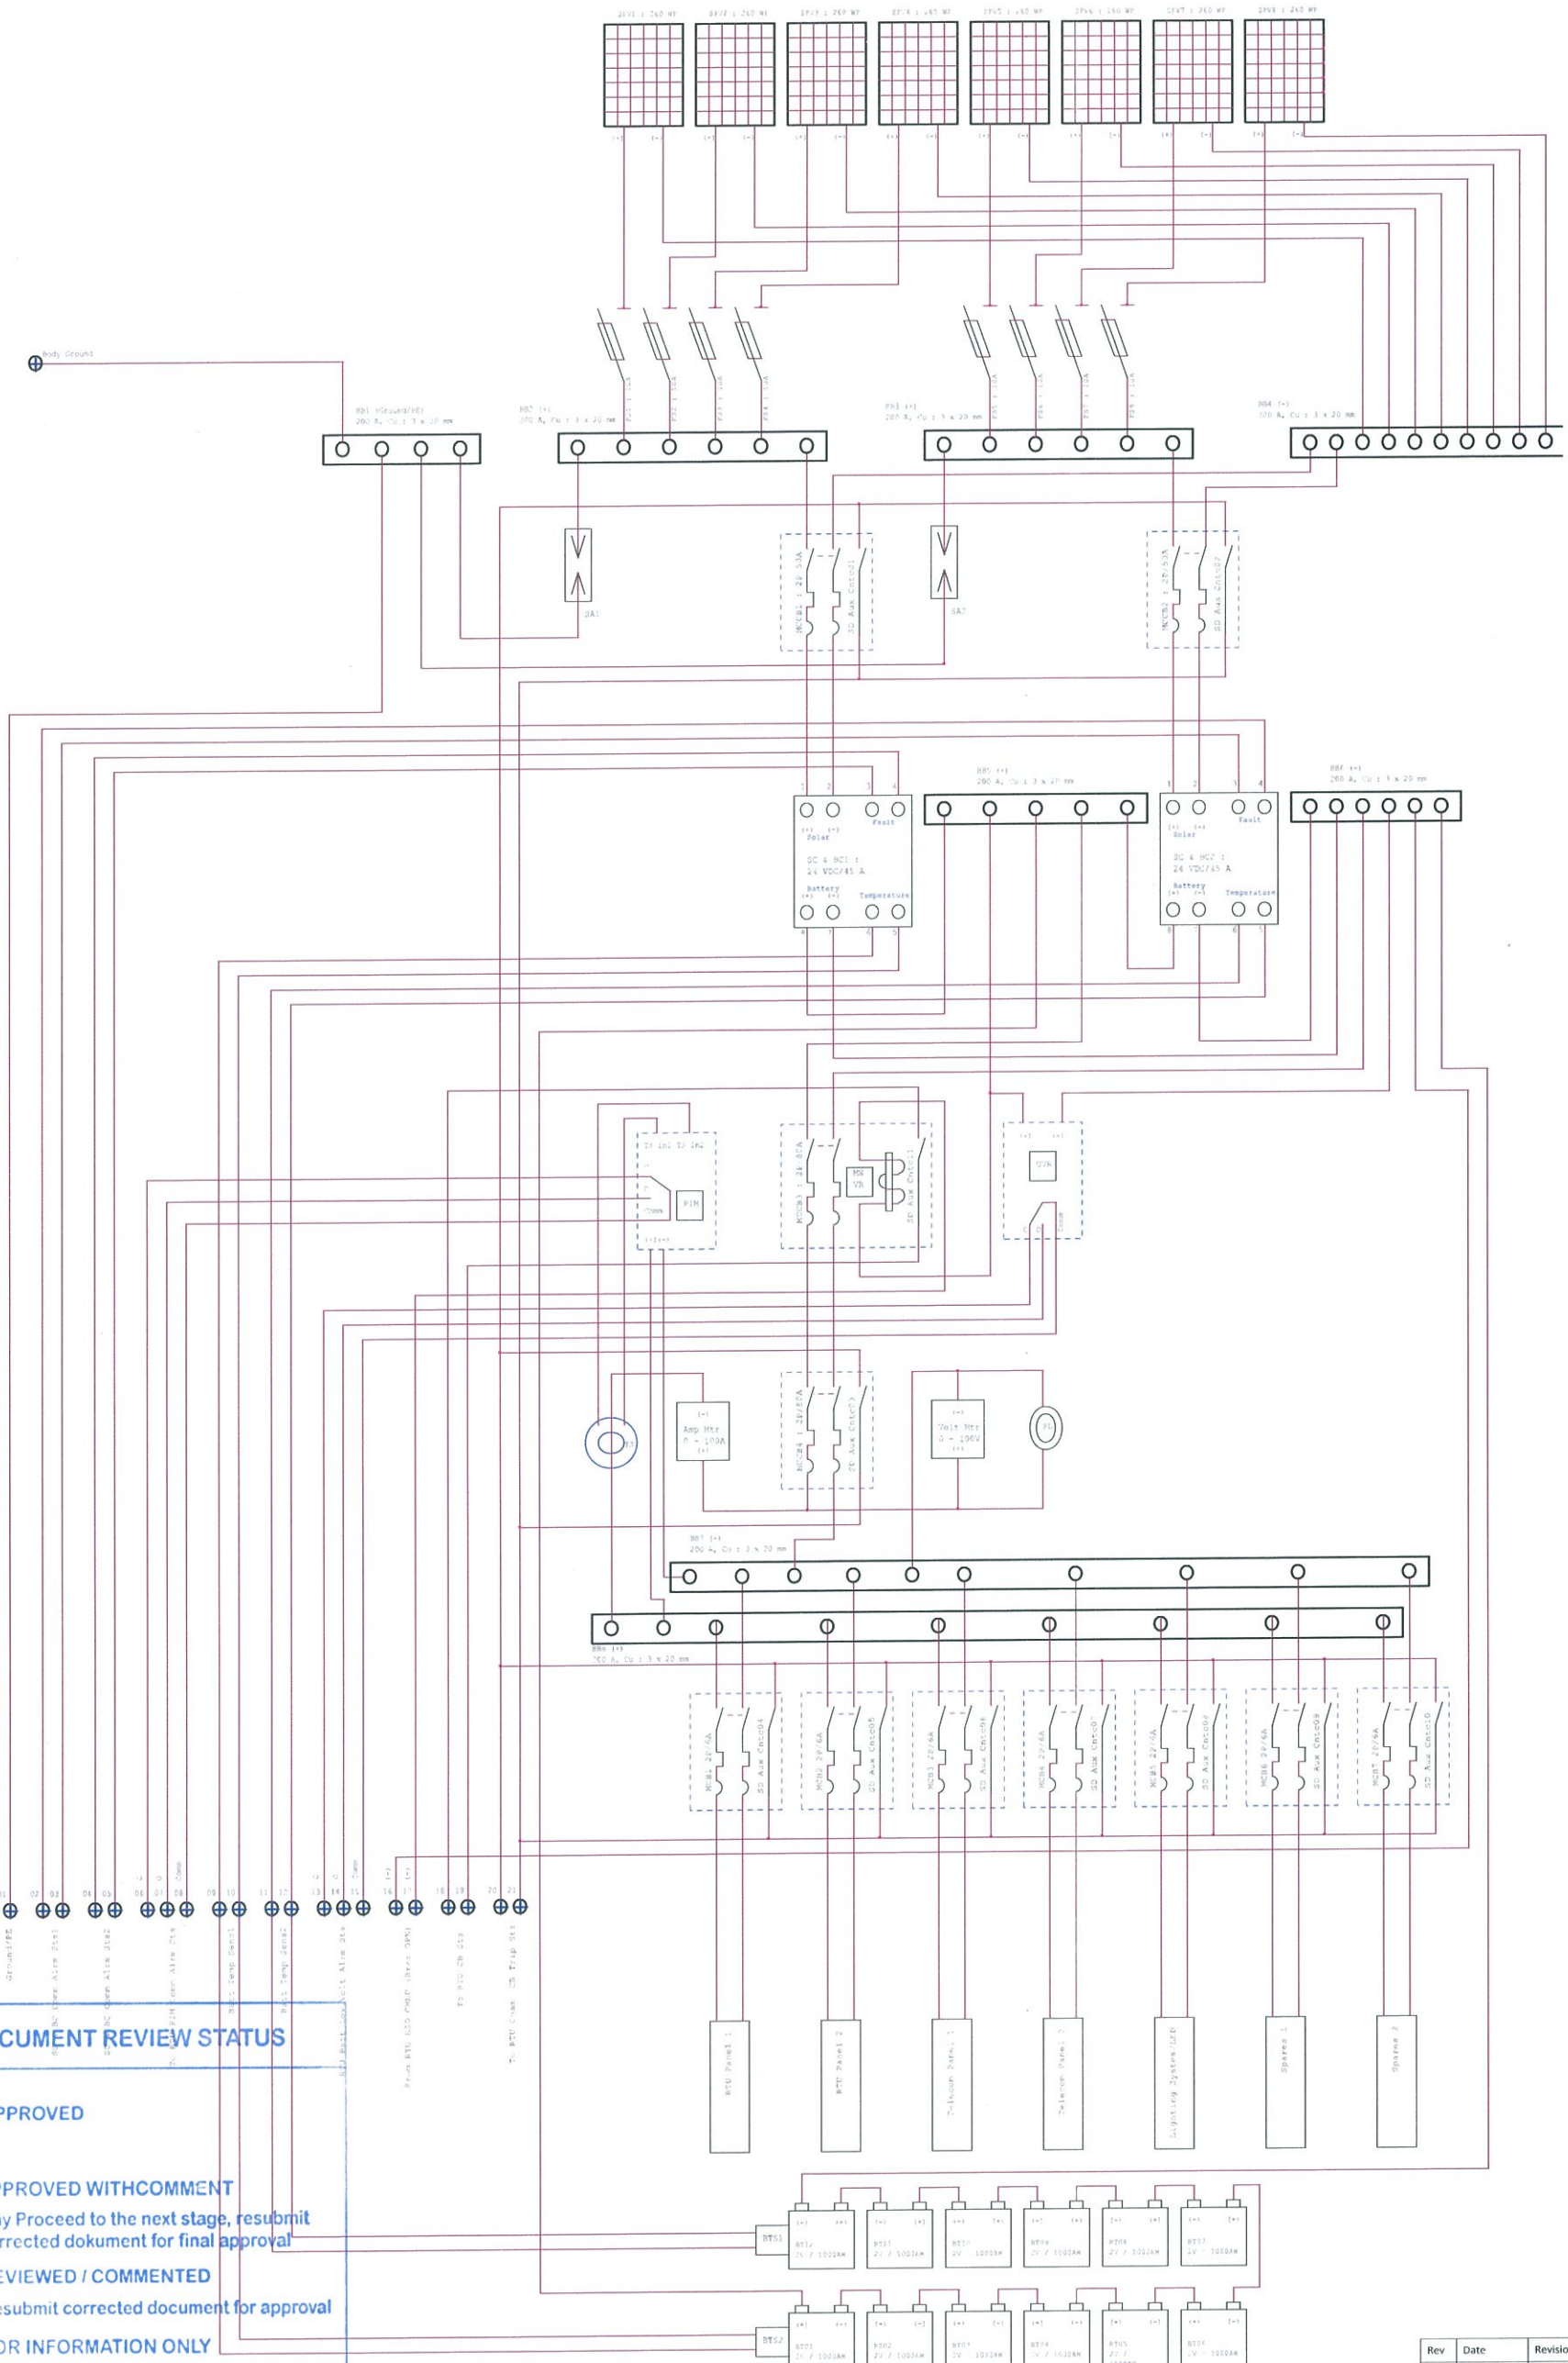

DOCUMENT REVIEW STATUS

☒ APPROVED

☐ APPROVED WITH COMMENT
May Proceed to the next stage, resubmit corrected dokument for final approval

☐ REVIEWED / COMMENTED
Resubmit corrected document for approval

☐ FOR INFORMATION ONLY

☐ REJECTED

CHECK BY	SS		10/2/2015
	Initial	Sign	Date
ACKN BY			
	Initial	Sign	Date

ORIGINAL

Rev	Date	Revision	Chk	Apv
C	02/09/2015			
Scale	Designed		Drawn	
	JGP		JKO	
Client : Pertamina Gas				
Contractor : CPM Konsorsium				
Vendor : PT. Jayakarta Global Pratama				
Project : Jasa Perancangan Pengadaan Konstruksi dan Komisioning Pipa Transmisi Gas dari Belawan – Kim-Kek				
Title : Solar Panel & Battery Bank : Single Line Diagram : PDB System Wiring				
Drawing No		File Name		
PG-BKK-SLD-DRW-04-01		PG-BKK-SLD-DRW-04-01		